


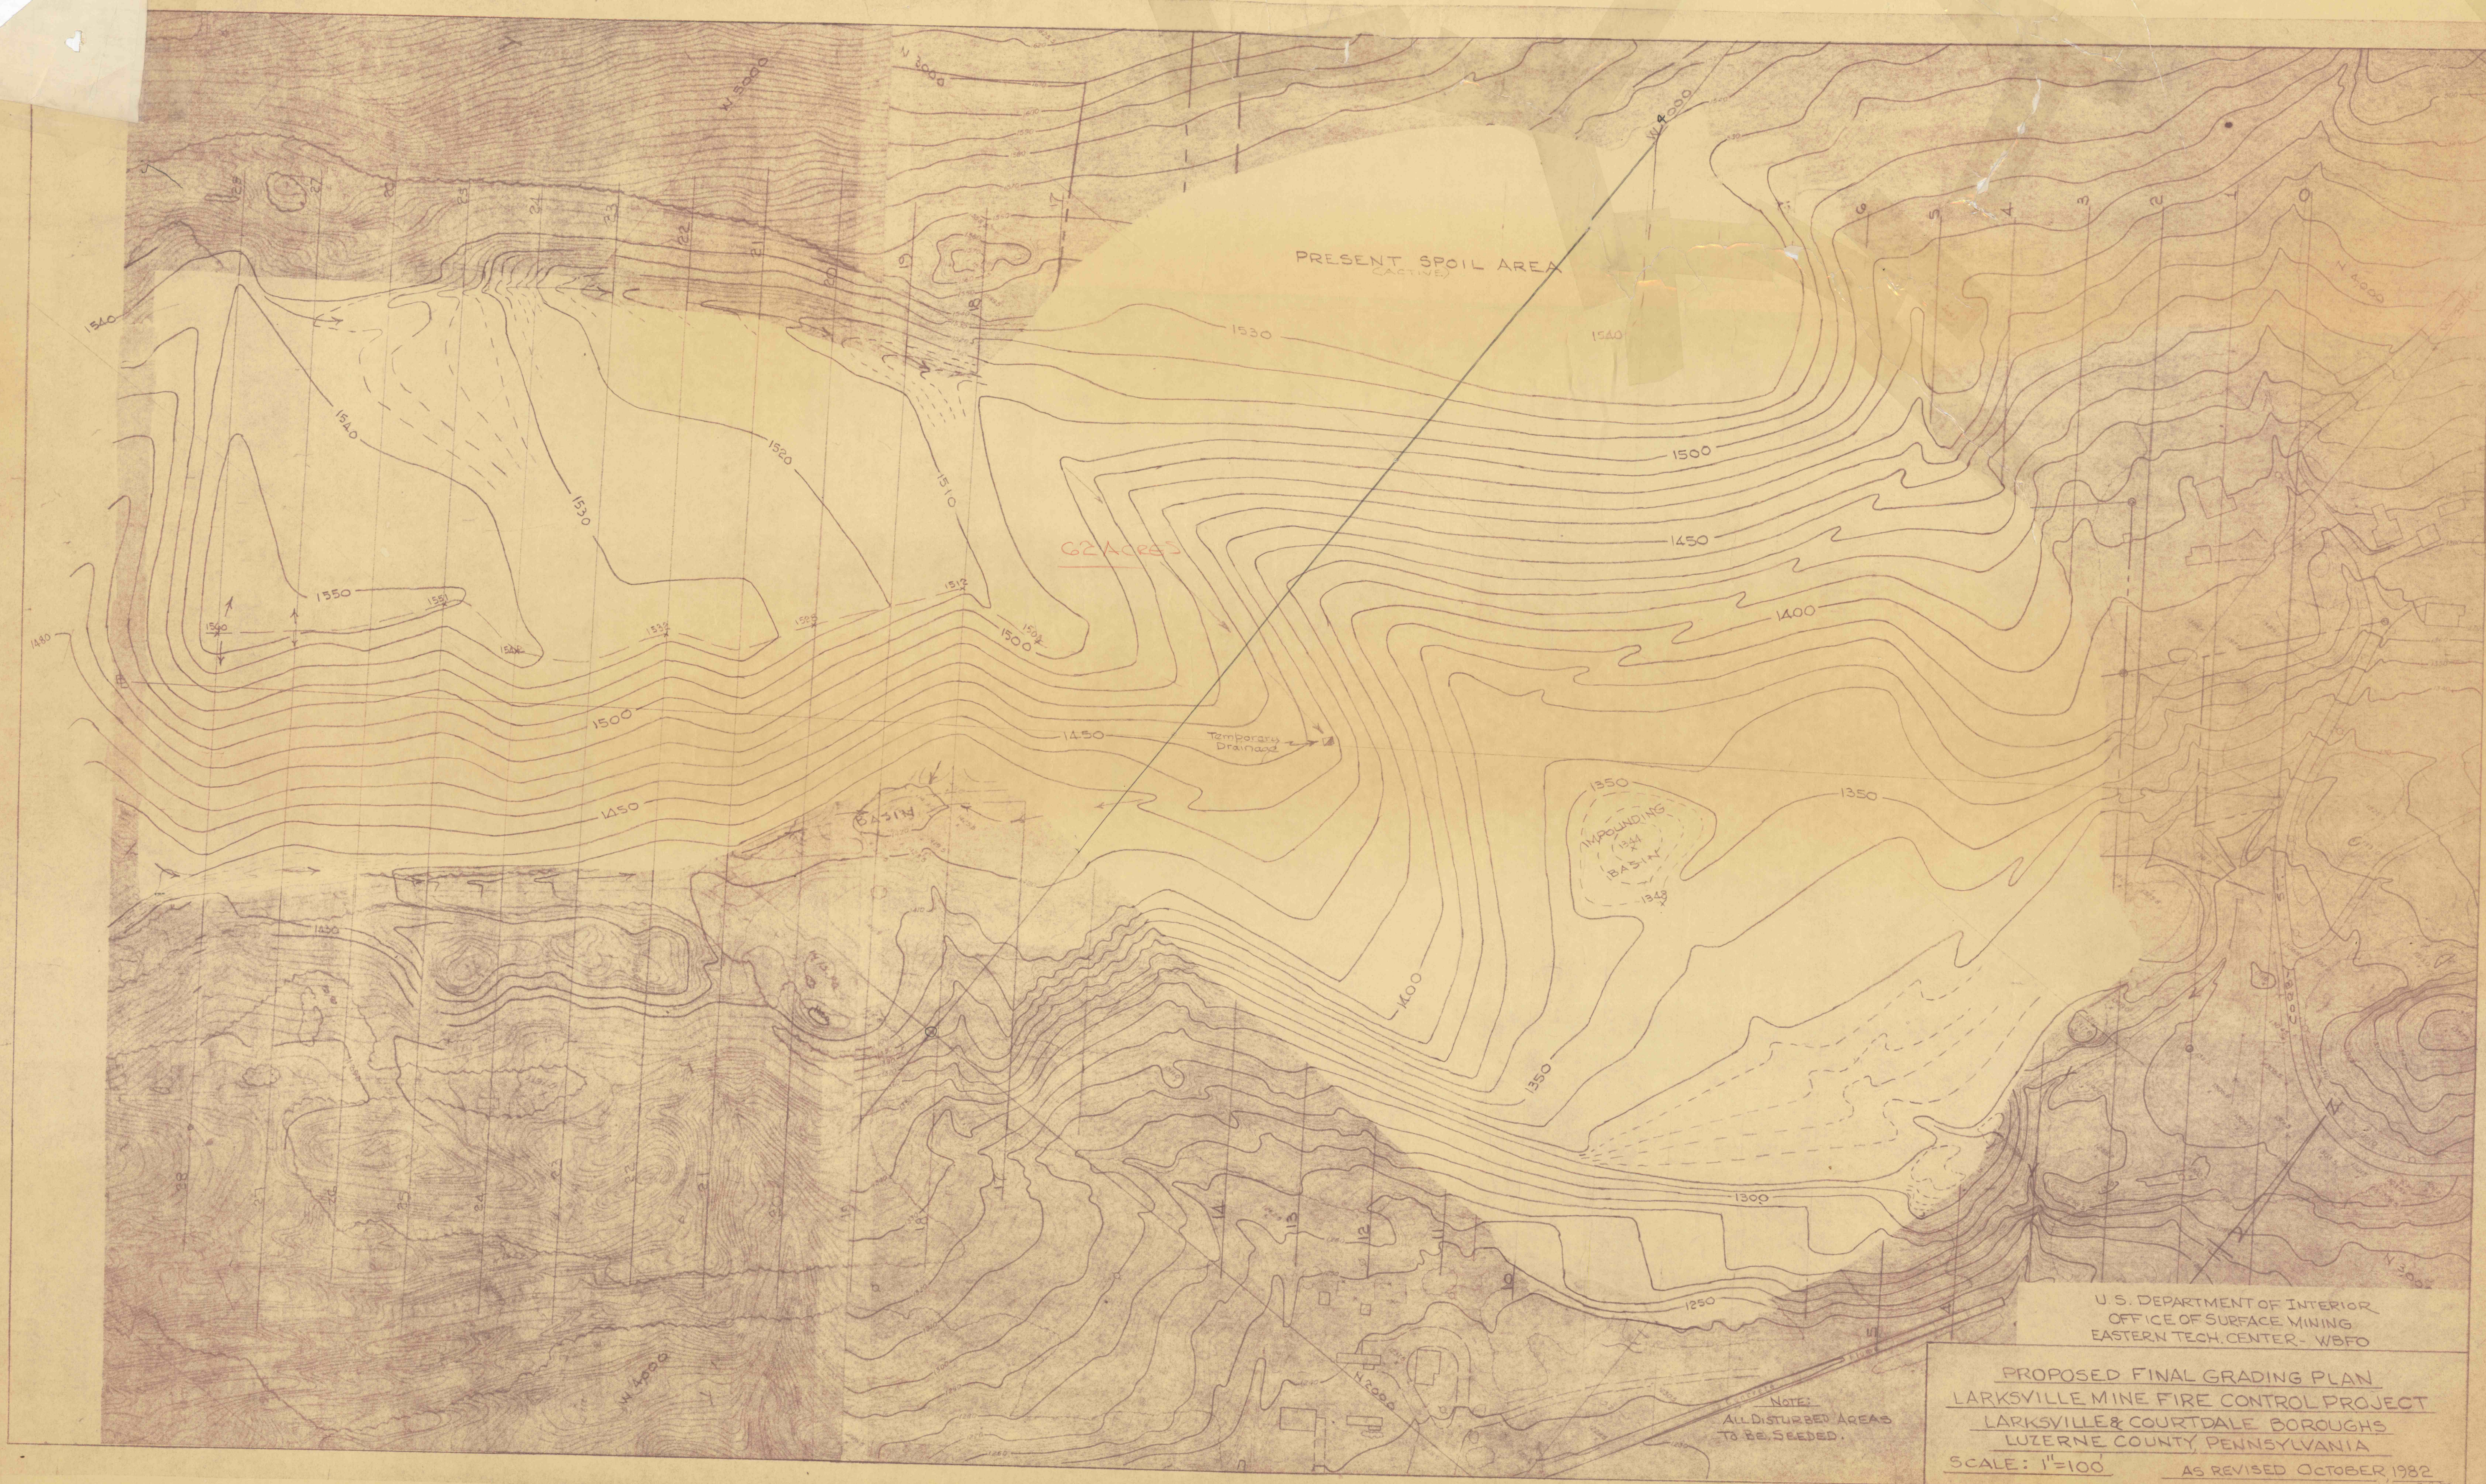

U.S. DEPARTMENT OF INTERIOR
OFFICE OF SURFACE MINING
EASTERN TECH. CENTER - WBFO

PROPOSED FINAL GRADING PLAN
LARKSVILLE MINE FIRE CONTROL PROJECT
LARKSVILLE & COURTDALE BOROUGHES
LUZERNE COUNTY, PENNSYLVANIA
SCALE: 1"=100' AS REVISED OCTOBER 1982

NOTE:
ALL DISTURBED AREAS
TO BE SEEDDED.