




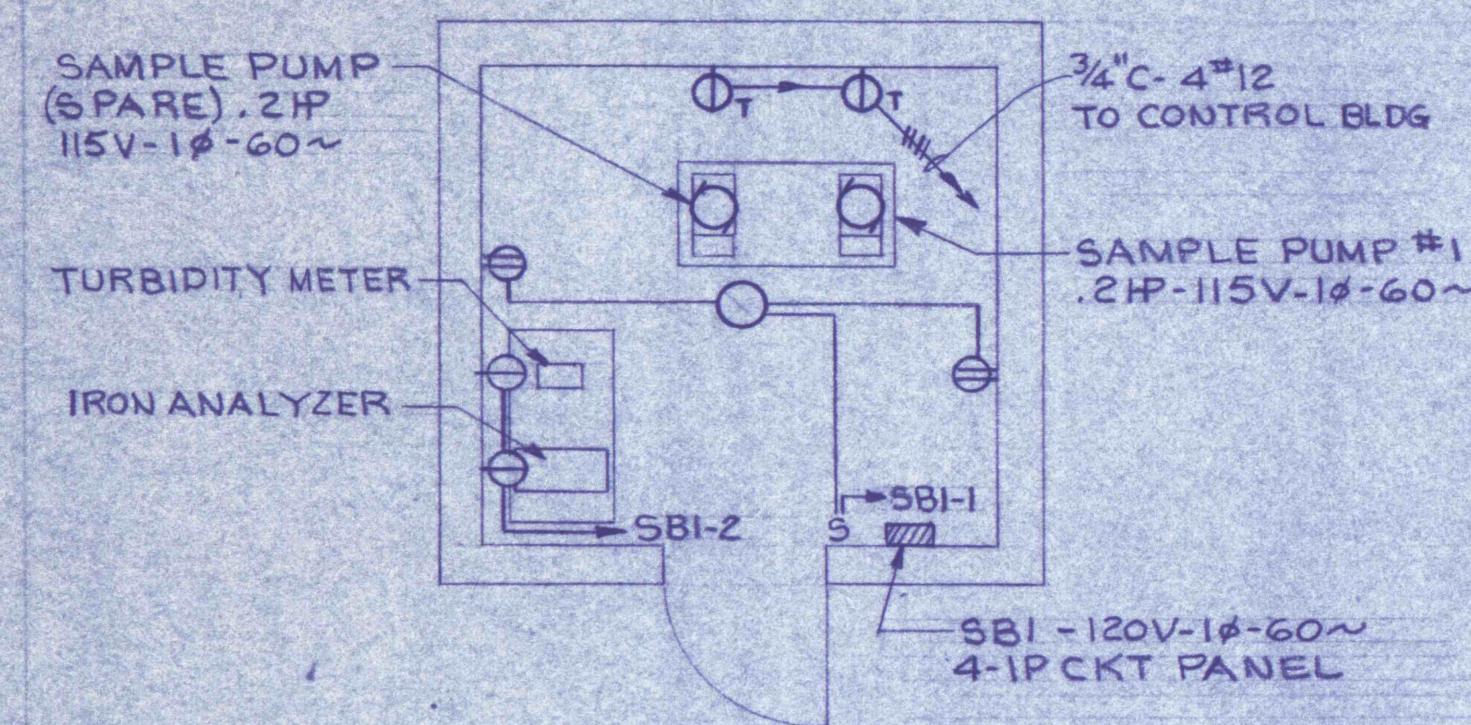


SAMPLE BLDG NO. 1
FLOOR PLAN
SCALE: $\frac{1}{4}" = 1'-0"$

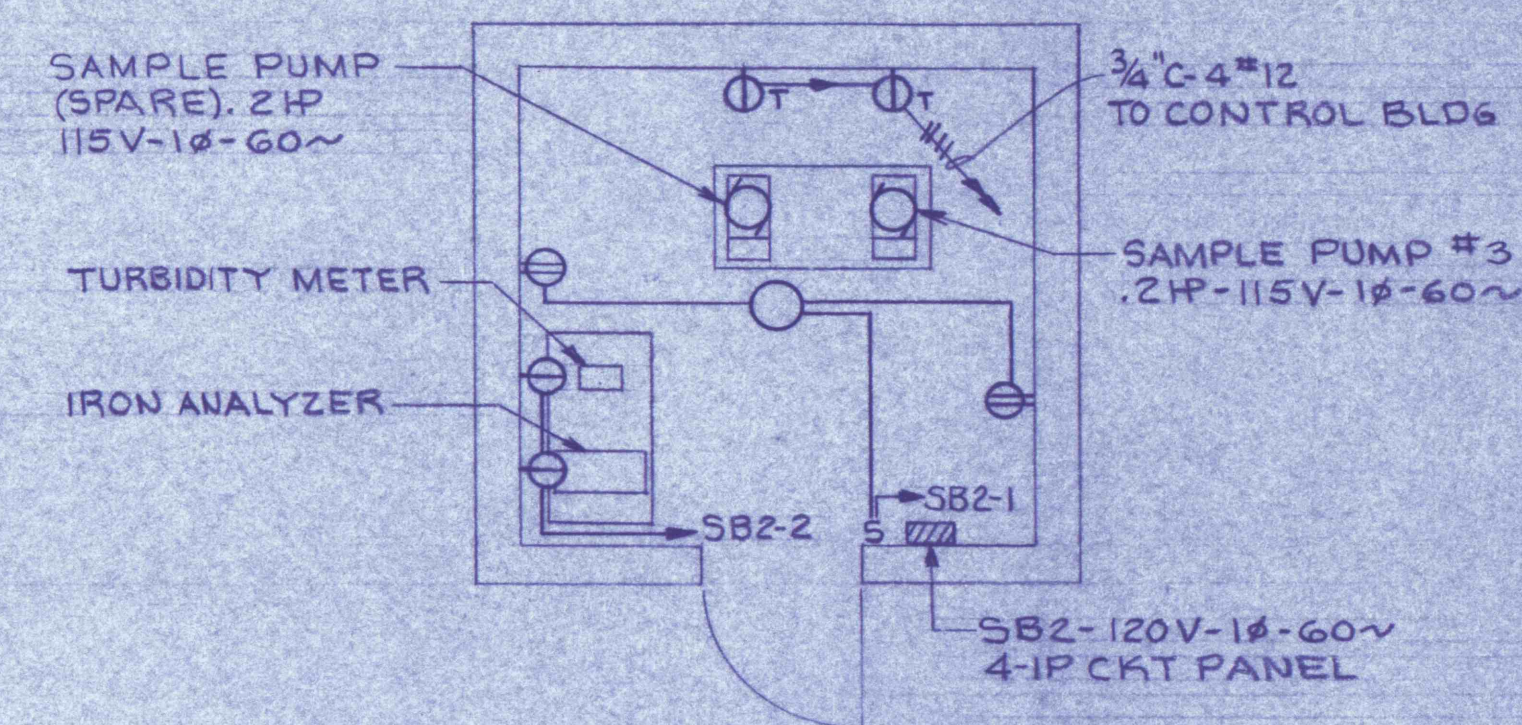


SAMPLE BLDG NO. 3
FLOOR PLAN
SCALE: $\frac{1}{4}" = 1'-0"$

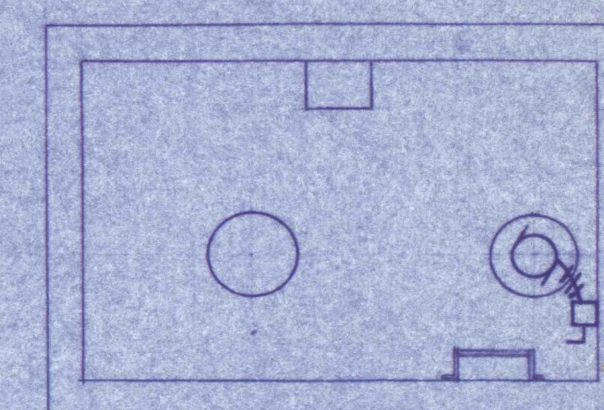


WELL HOUSE
SCALE: $\frac{1}{4}" = 1'-0"$

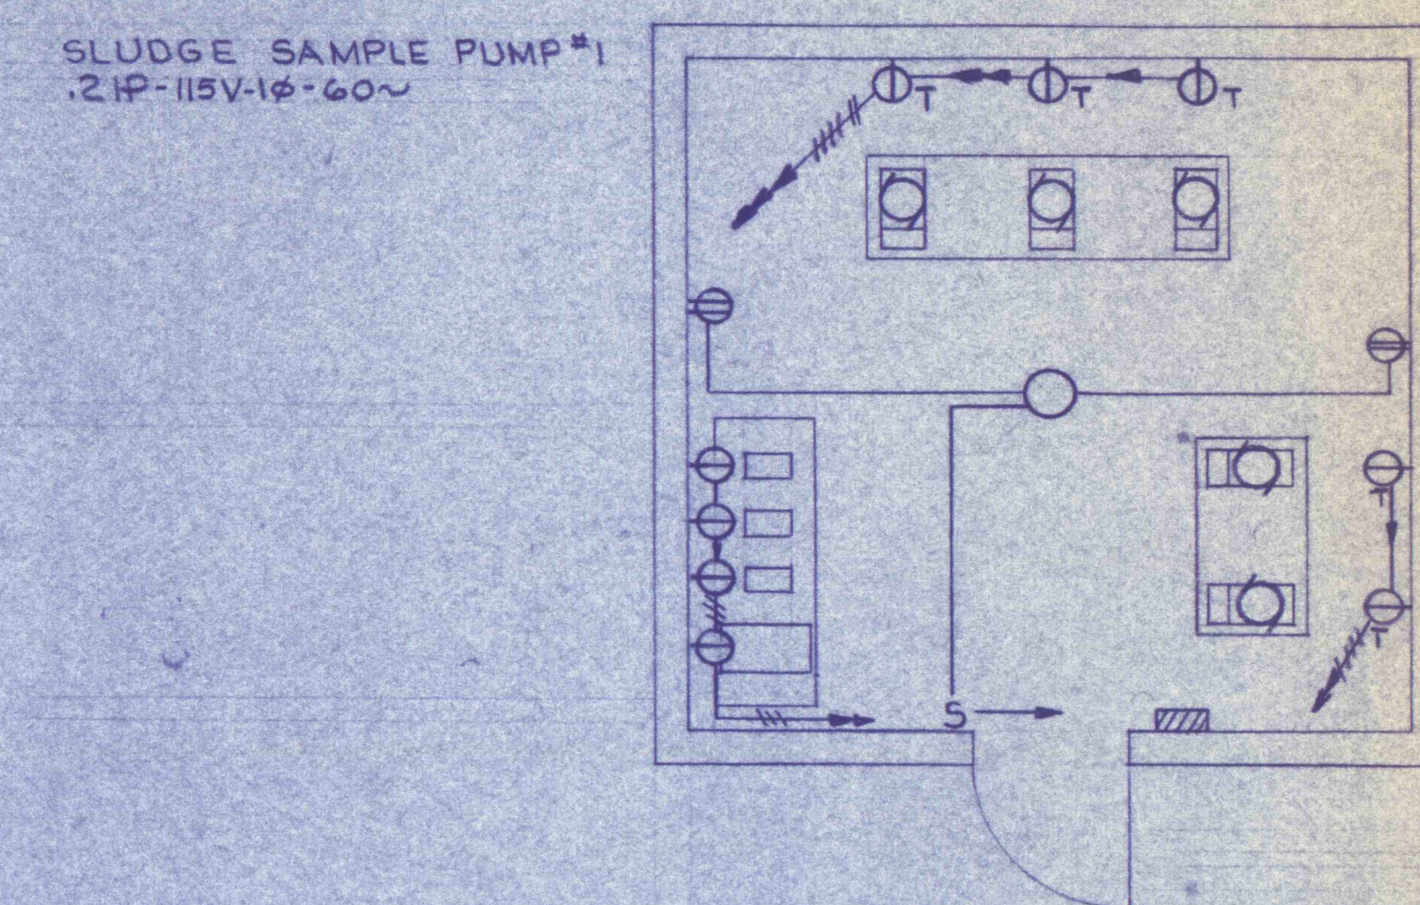

SAMPLE BLDG NO. 2
FLOOR PLAN
SCALE: $\frac{1}{4}" = 1'-0"$

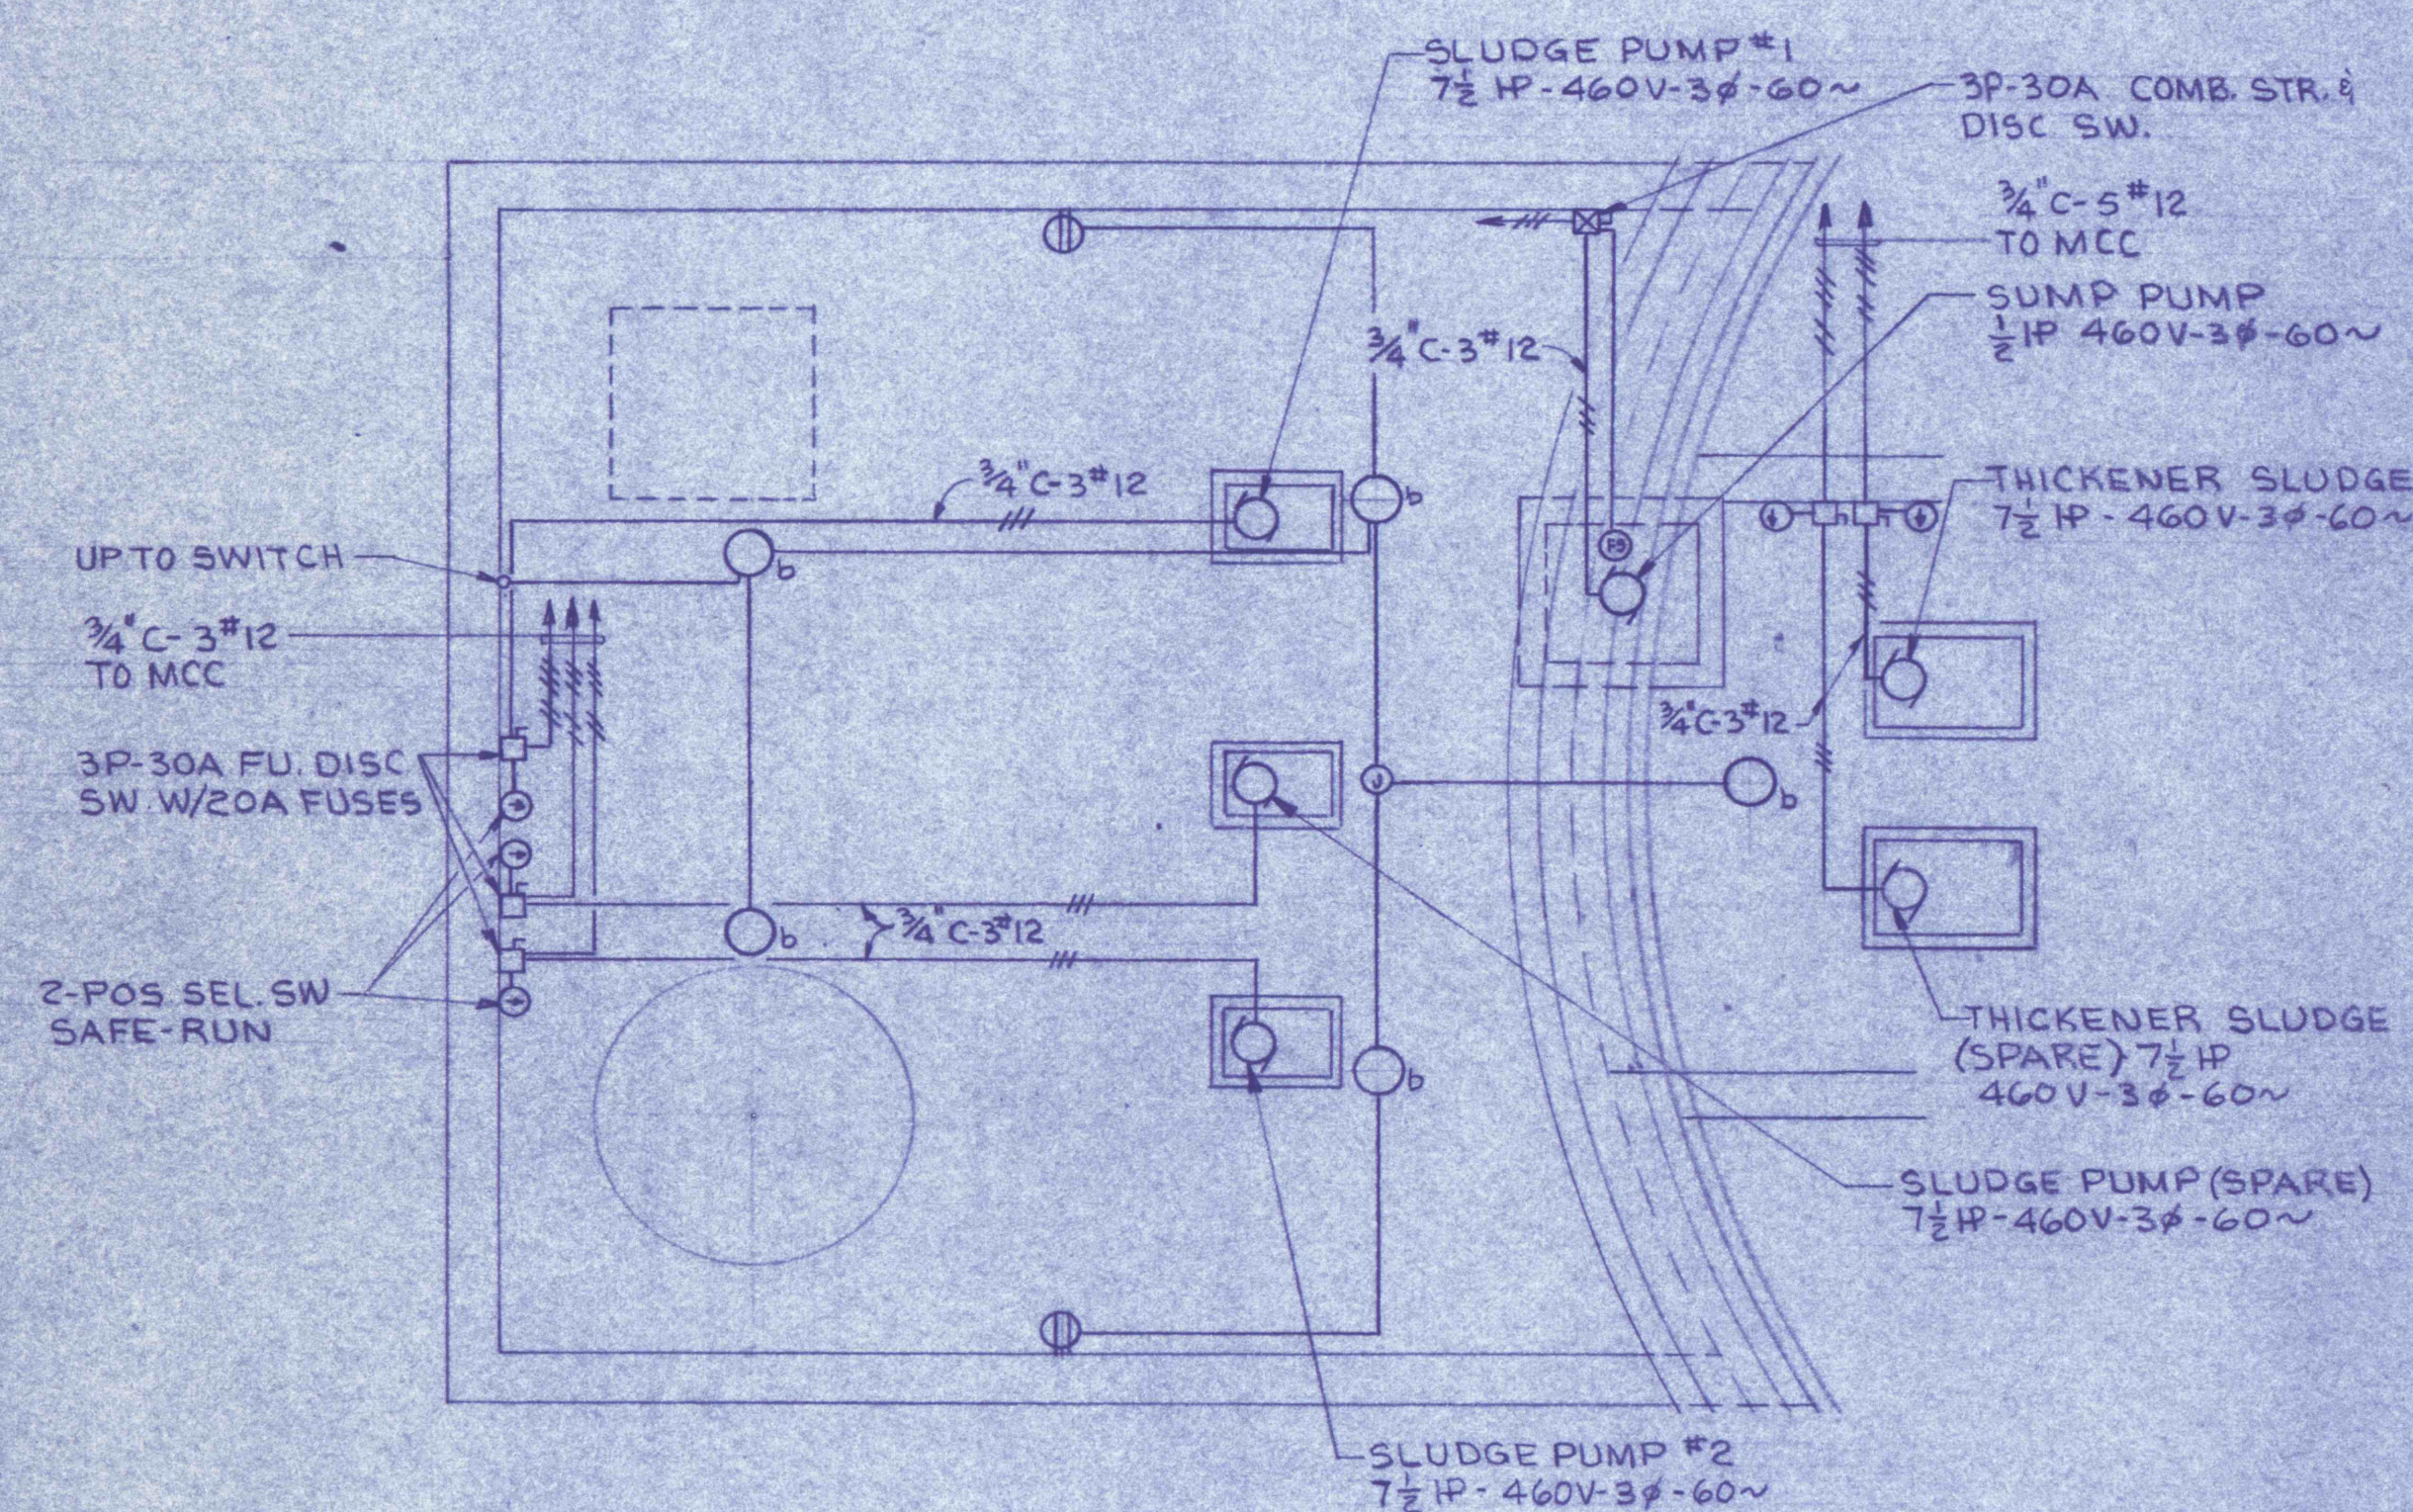

PLAN LOWER LEVEL
SCALE: $\frac{1}{4}" = 1'-0"$

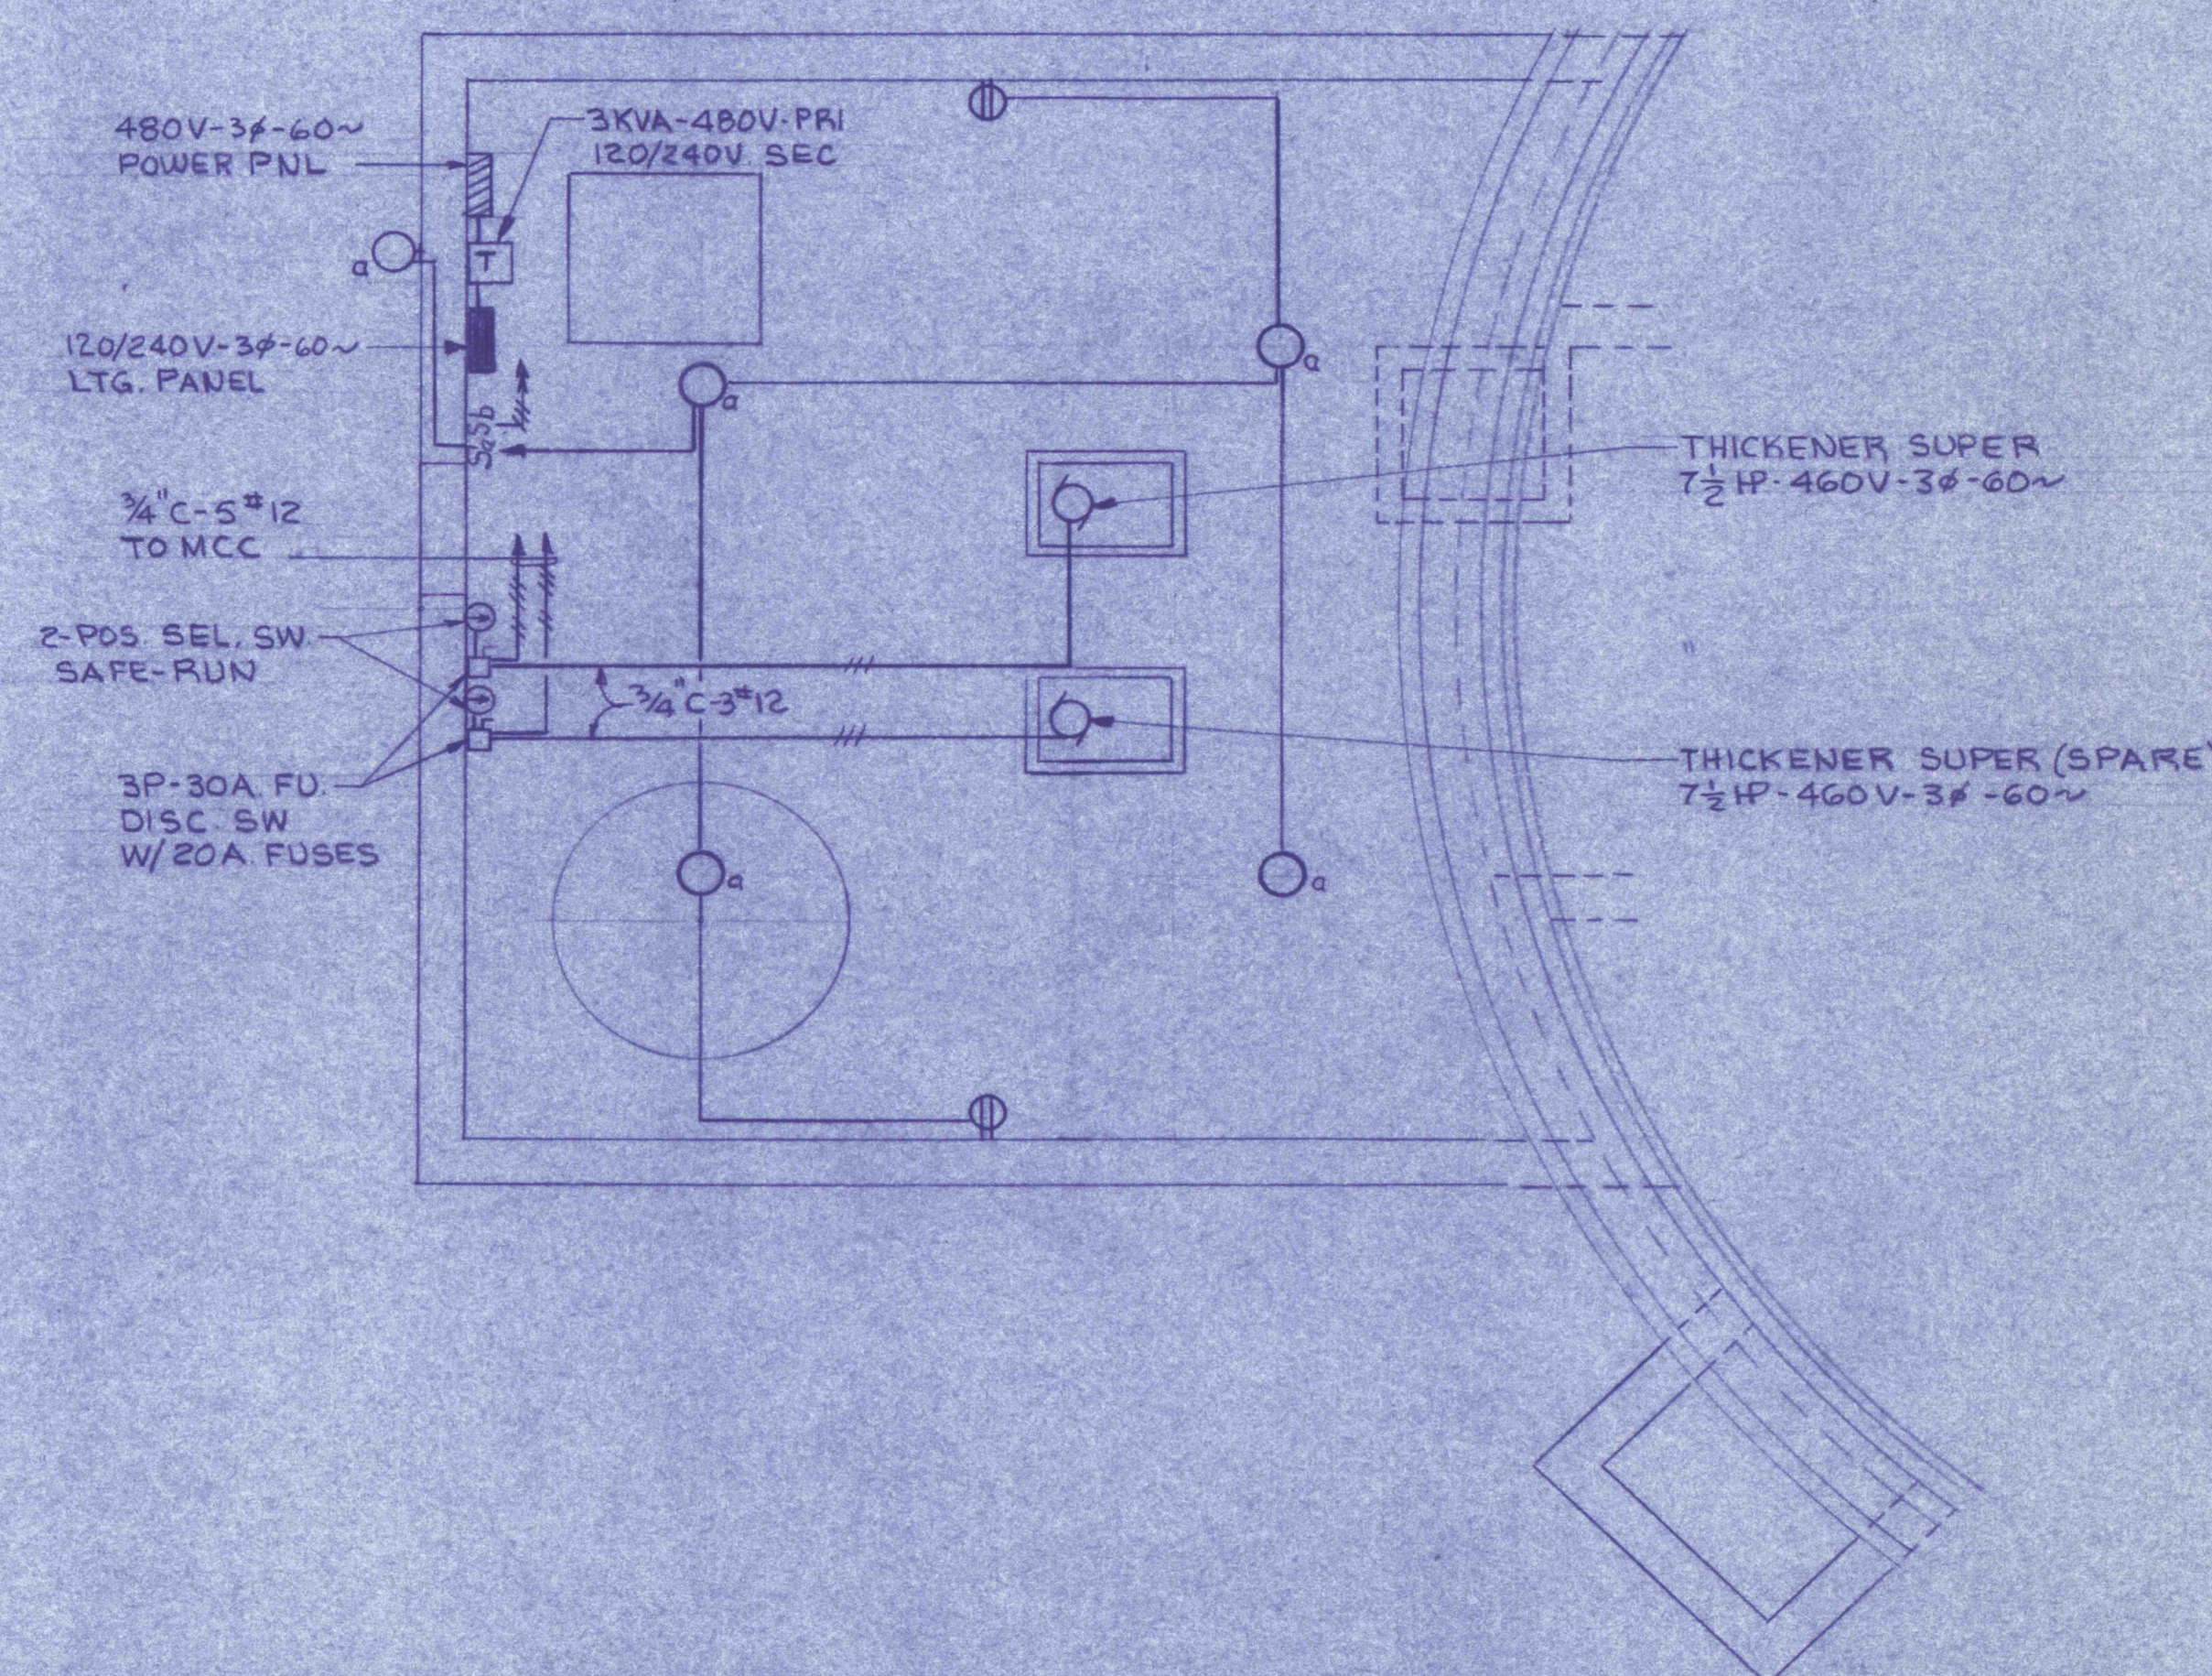

PLAN UPPER LEVEL
SCALE: $\frac{1}{4}" = 1'-0"$

THICKENER BLDG

REVISIONS	
OUTLYING STRUCTURE E.H.V. PLAN	
CONSTRUCTION OF TREATMENT FACILITIES FOR ACID MINE DRAINAGE	
RAUSCH CREEK WATERSHED	
SCHUYLKILL COUNTY PENNSYLVANIA	
ANTRACITE RESEARCH & DEVELOPMENT CO. INC. consulting engineers POTTSVILLE PENNSYLVANIA	
TAMAGUA	
JOB NO: 5805 DATE: NOV. 1969 SCALE: AS NOTED DRAWN: U.J. U. APPROVED:	DRAWING NO: EHV-1