


PANEL 'A' 120/240V 3Φ 3W					
NO.	CIRCUIT	NO.	CIRCUIT	NO.	CIRCUIT
1	CONDENSER	2	SPACE		
3		4			
5		6			
7	SPACE	8			
9		10			
11		12			

PANEL 'B' 120/240V 1Φ 3W					
NO.	CIRCUIT	NO.	CIRCUIT	NO.	CIRCUIT
1	LTS	2	BOILER		
3	REC.	4	REC.		
5	REC.	6	REC.		
7	REC.	8	LTS		
9	LTS YOK FAN	10	LTS		
11	REC.	12	LTS		
13	LTS	14	LTS		
15	REC.	16	REC.		
17	REC.	18	LTS		
19	WATER HEATER	20	AIR HANDLER		
21	SPACE	22			
23	SPACE	24	SPACE		
25	SPACE	26	SPACE		
27	SPACE	28	SPACE		
29	SPACE	30	SPACE		


TOTAL CONN 24.7 KW - 102.9 A

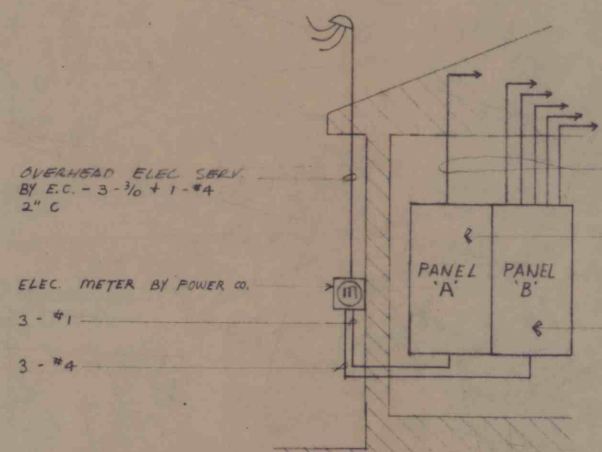

SERVICE ENTRANCE ON SCALE

SYMBOLS

- 2' x 4' TROFFER - 4 40W FL
- 2' x 2' TROFFER - 2 20W FL
- 4' STRIP - 2 40W FL
- 2' x 2' TROFFER MTD OVER MIRROR
- SYLVANIA ALBY R47 - 70W NPS
- HALO HI-11 100W INC
- FAN-LIGHT COMB. - NUTONE BL72 - 1 100W INC
- DUPLEX OUTLET - 2'-0" ABOVE F.F.
- TELEPHONE OUTLET - 3/4" COND. TO ABOVE CEILING
- POWER CONNECTION

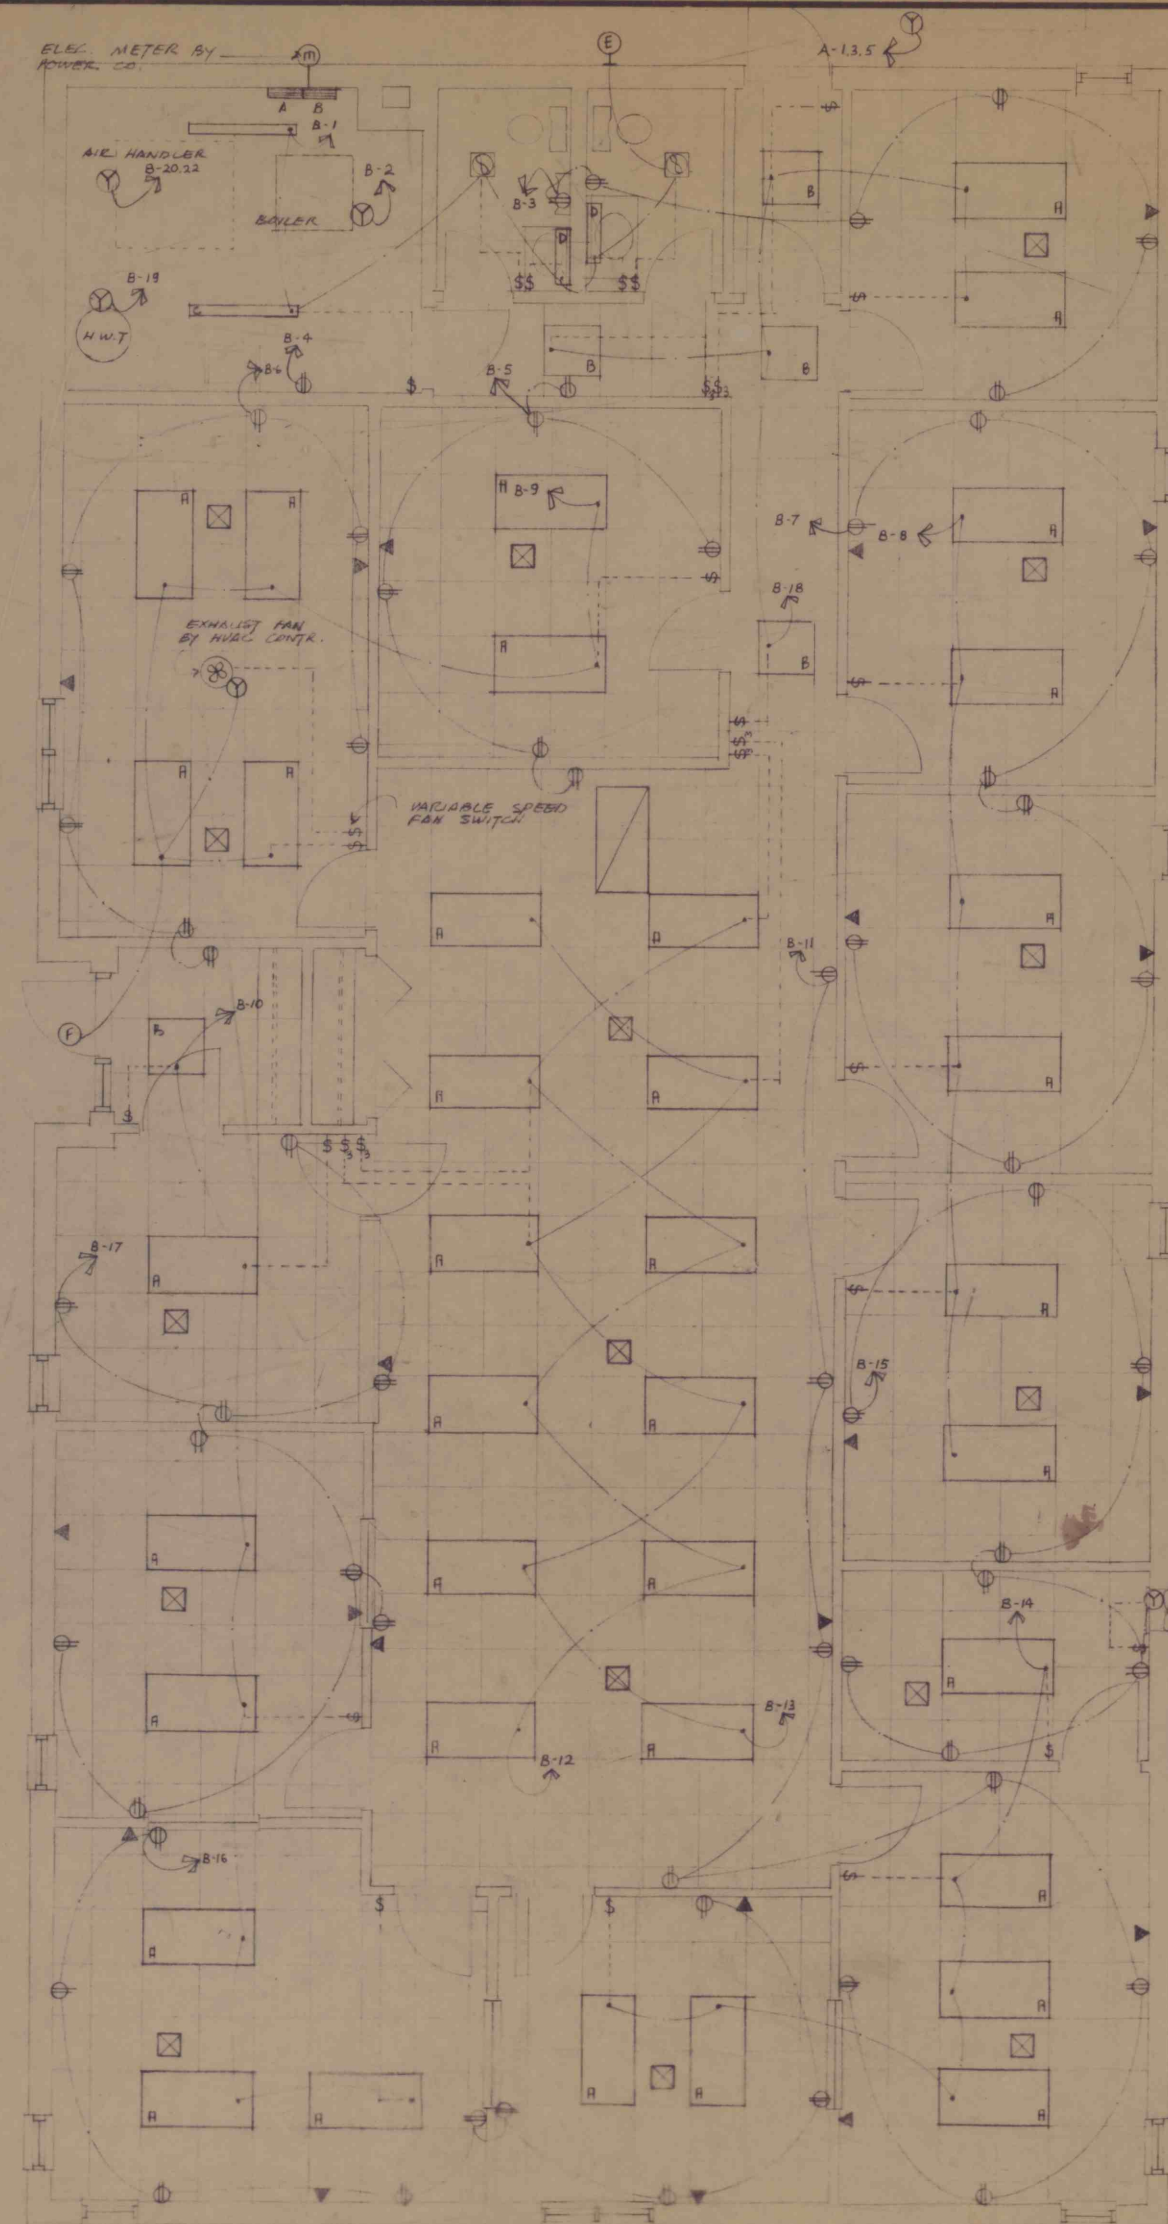


ELECTRICAL FLOOR PLAN 1/4" = 1'-0"

FINAL CONTRACT DRAWINGS

NEW OFFICE BUILDING
FOR P & N COAL CO.
WEST MAHONING ST.
PUNXSUTAWNEY PA.

KRING & TEPLICA
ARCHITECTS

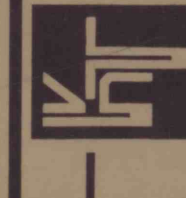

JAMES H. KRING, P.A.
JOHN W. TEPLICA, P.A.
PHONE (610) 371-1141

MAR 1 1962
MAR 6 1962
APR 10 1962
JUN 1 1962

E