


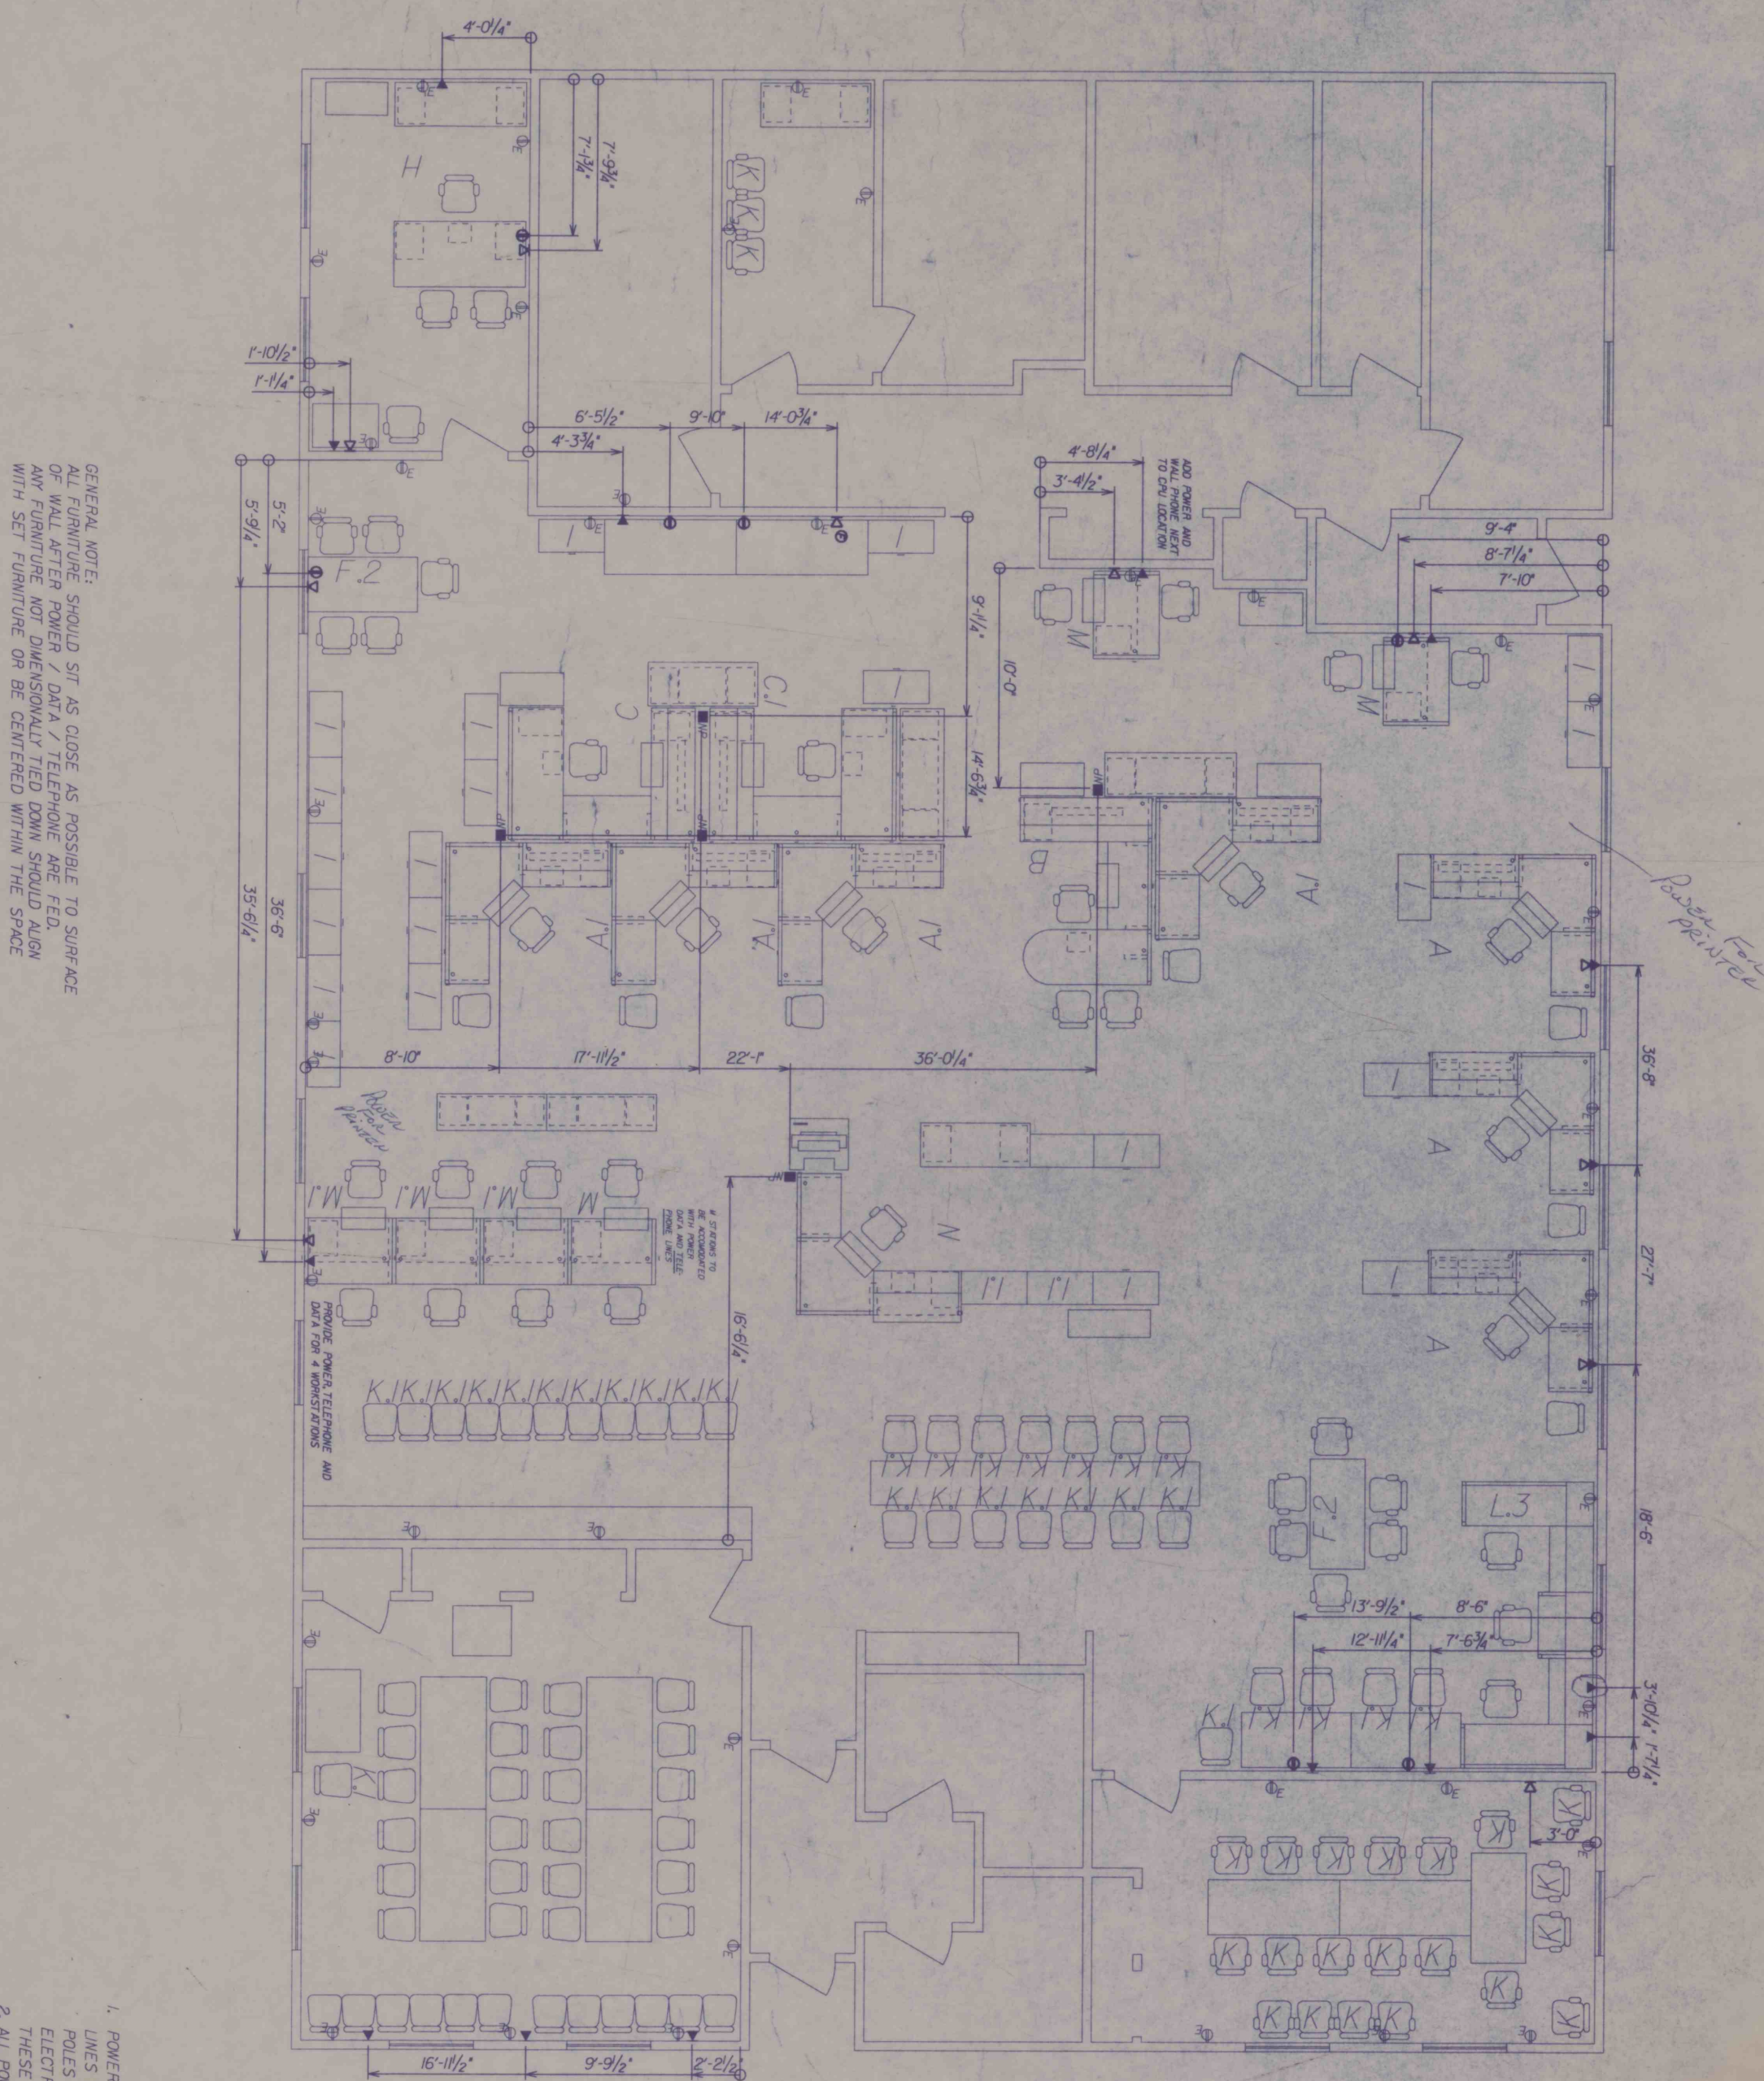

GENERAL NOTE:
ALL FURNITURE SHOULD SIT AS CLOSE AS POSSIBLE TO SURFACE
OF WALL AFTER POWER / DATA / TELEPHONE ARE FED.
ANY FURNITURE NOT DIMENSIONALLY TIED DOWN SHOULD ALIGN
WITH SET FURNITURE OR BE CENTERED WITHIN THE SPACE

1. POWER LINES WILL SERVICE MULTIPLE WORKSTATIONS; IF THE NUMBER LINES WILL NOT FIT OR IF THE MANAGER CHOOSES TO HAVE SEPARATE POLES FOR STAFF ADDITIONAL POLES MAY BE USED OR ADDED. THE ELECTRICAL PLAN SHOWS LOCATION ONLY AND DOES NOT ADDRESS HOW THESE LOCATIONS ARE WIRED.
2. ALL POWER POLE LOCATIONS ARE TO HAVE ELECTRICAL PHONE AND DATA GUESSES NOTED OTHERWISE
3. WHERE FLOOR COMMENTS ARE TO BE REMOVED AND THE FLOOR PATCHED THE BOX WILL BE CROSSED OFF.
4. WHERE DIMENSIONS AREA PROVIDED THE POLE MUST BE WITHIN INCH OF THE LOCATION
5. WALL LOCATOR FOR POWER DATA AND TELEPHONE TO BE LOCATED WITHIN 6 INCHES OF DIMENSIONED LOCATION.
6. SPECIAL LINES (Dedicated CIRCUITS OR POWER SHOULD BE REVIEWED WITH THE MANAGER AT THE TIME OF THE ELECTRICAL INSTALLATION.

☐ Total quantity of power and telephone capacity

☐ Locations of power and telephone receptacles in the general office areas
☐ Locations for any nonstandard outlets (i.e. dedicated lines)

I accept the Furniture Plan with the following revisions
Thank to be able to view and data

— I hope the people of our world
you find in the way, I'd like — I'll

100

10. 2. 1907

Office Manager's Signature *John D. Smith*

Digitized by Google

18

16000.400	3
16000.401	4
16000.500	1
16000.600	1
16000.700	1
16000.801	2
16000.900	1
16000.100	2
16000.101	2
16000.102	2
16000.103	3
16000.104	3
16000.105	3
16000.106	1

SYMBOLS LEGEND

- | | | |
|---|------------------|---|
|  | R_{new} | existing duplex resistor |
|  | R_{new} | new duplex resistor |
|  | R_{new} | existing four-pole resistor |
|  | R_{new} | new four-pole resistor |
|  | R_{new} | existing dedicated resistor |
|  | R_{new} | new dedicated resistor |
|  | R_{new} | existing calling resistor |
|  | R_{new} | existing power pole |
|  | R_{new} | new power pole location with power, telephone & data unless otherwise indicated |
|  | R_{new} | existing four resistors |
|  | R_{new} | existing resistor |
|  | R_{new} | new resistor |
|  | R_{new} | existing data |
|  | R_{new} | new data |
|  | R_{new} | existing telephone/data resistor |
|  | R_{new} | new telephone/data resistor |
|  | R_{new} | existing fax |
|  | R_{new} | new fax |
|  | R_{new} | existing thermostat |
|  | R_{new} | existing fire extinguisher |
|  | R_{new} | existing switch |
|  | R_{new} | existing diffuser |

Prepared for Haskell of Pittsburgh, Inc., 231 Haskell Lane, Verona, Pa. 15147-6262 for Labor & Industry - Dept. General Service

Labor and Industry
Department of Employment Securities

Power and Telephone Plan
Punxsutawney Area Job Center #720

FINAL

Drawn by
REF/AKB
Checked by
JMF
Date Issued
02/14/94
Date Printed

Revisions
1. 02/22/94 AKB

Burt Hill Kosar Rittelmann Associates

400 Morgan Center
Butler, PA 16001
412-285-4761
FAX: 412-285-6815

125 South Ninth Street
Philadelphia, Pa. 19107
215-574-8200
FAX: 215-574-8245

