


LEGEND

- AIR SUPPLY LINE
- AIR RETURN LINE
- GAS LINE

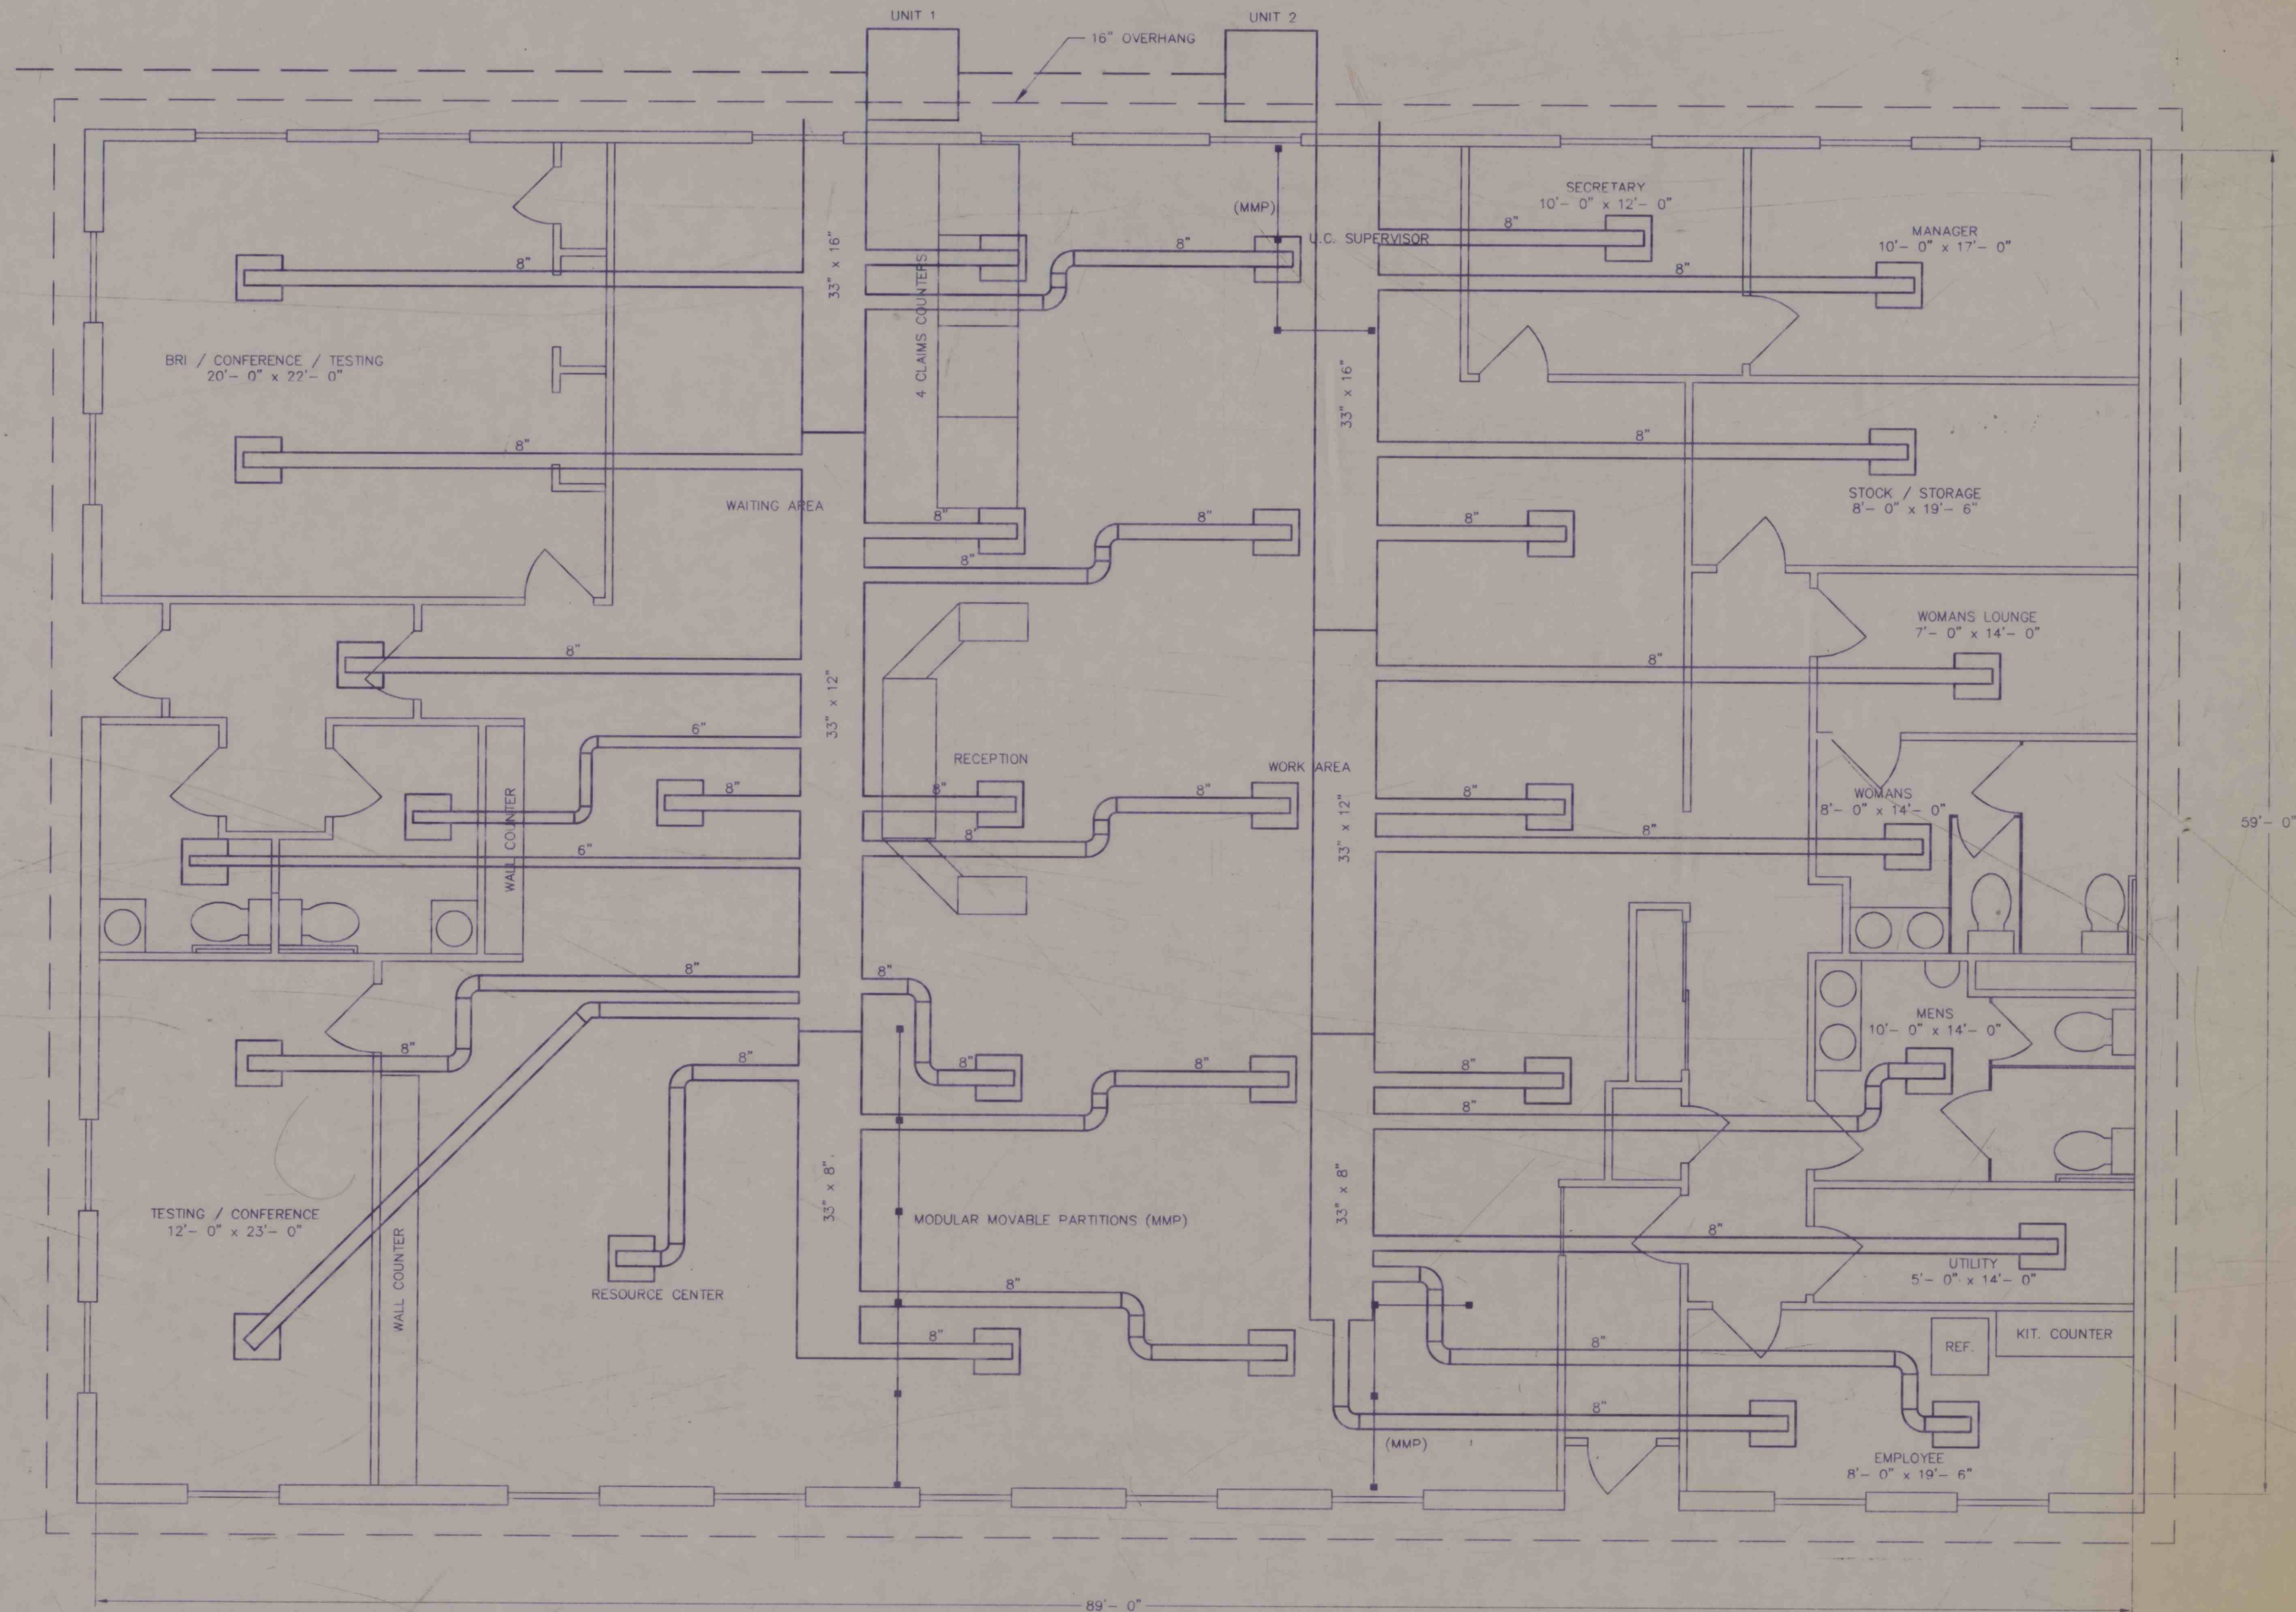

LEE - SIMPSON ASSOCIATES, INC.
CONSULTING ENGINEERS
203 WEST WEBER AVE.
DUBOIS, PA 15801 (814) 771-7750

DESIGNED BY: M.R.D.
CHECKED BY: S.K.
DATE: 6-29-93
SCALE: 1/4" = 1'-0"

DISK NO. 2
PLOT NO. 89313001

APPROVED: _____
DATE: _____
APPROVED: _____
DATE: _____
APPROVED: _____
DATE: _____
REG. NO. _____
ENGINEER

JOB CENTER
602 EAST MAHONING STREET
HEATING PLAN
PUNXSUTAWNEY PA.

SHEET

H1

OF 7 SHEETS