


LEGEND

--- PROPERTY LINE
 --- PROPOSED 2FT CONTOUR
 --- PROPOSED 10FT CONTOUR

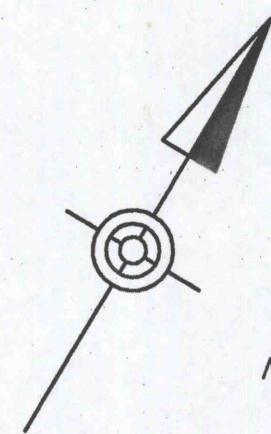

NARDONE BROTHER BAKING
 COMPANY
 D.B. 2724, PG. 486


CAVANAUGH ELECTRICAL
 CONTRACTING, INC.
 D.B. 2724, PG. 486

LUZERNE COUNTY INDUSTRIAL
 DEVELOPMENT AUTHORITY
 D.B. 2144, PG. 536

ROCCO DOMIANO
 D.B. 1971, PG. 331


ROCCO DOMIANO
 D.B. 1971, PG. 331

ROCCO DOMIANO
 D.B. 1971, PG. 331

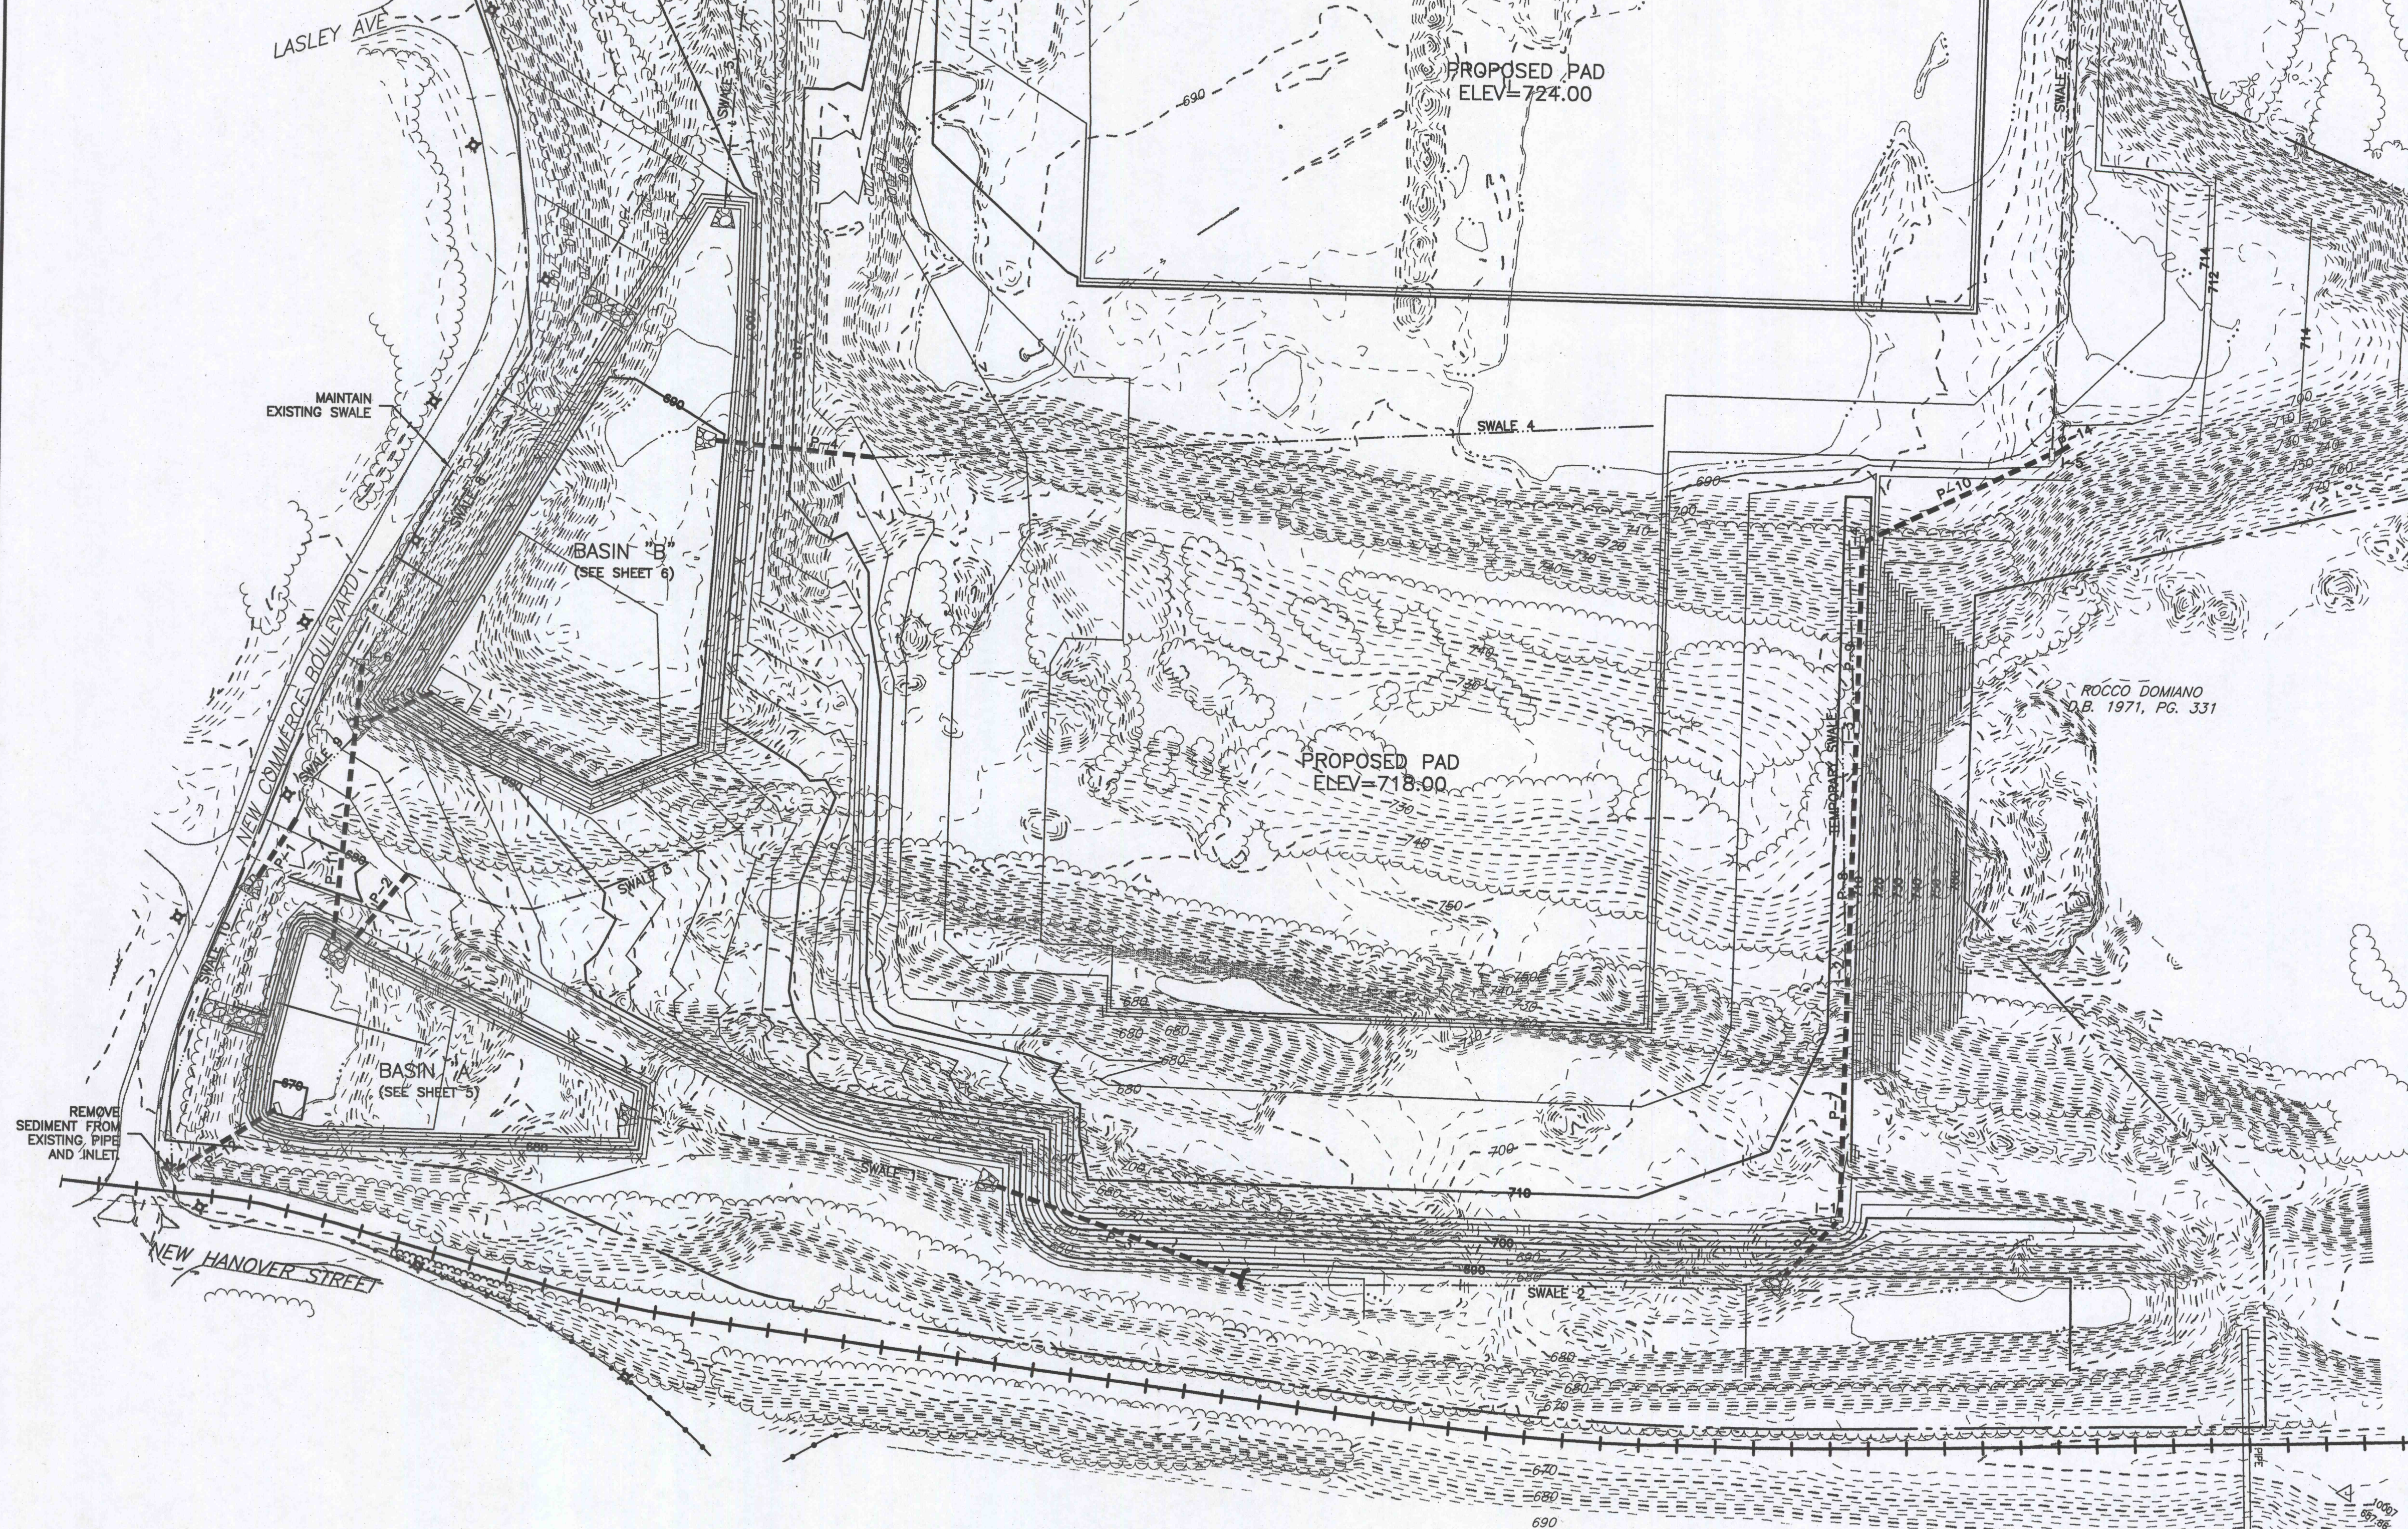

PIPE SCHEDULE					
PIPE	SIZE	TYPE	UPPER INVERT ELEVATION	LOWER INVERT ELEVATION	LENGTH (FT)
P-1	18	SLCPP	675.50	674.00	74
P-2	18	SLCPP	679.00	672.00	105
P-3	36	SLCPP	694.00	682.00	270
P-4	24	SLCPP	703.00	690.00	167
P-5	30	SLCPP	703.00	700.00	129
P-6	24	SLCPP	695.75	689.00	81
P-7	24	SLCPP	701.09	695.95	257
P-8	24	SLCPP	705.15	701.29	257
P-9	24	SLCPP	708.26	705.35	233
P-10	24	SLCPP	710.69	708.46	203
P-11	15	SLCPP	681.00	672.00	290
P-12	24	SLCPP	669.90	669.00	121
P-13	24	SLCPP	685.90	683.00	72
P-14	15	SLCPP	711.25	710.89	18

STORM STRUCTURE SCHEDULE					
STRUCTURE	RIM ELEV.	PIPE NO. IN	PIPE NO. OUT	REMARKS	
I-1	707.90	P-7	P-6	TYPE M INLET	
I-2	709.50	P-8	P-7	TYPE M INLET	
I-3	709.50	P-9	P-8	TYPE M INLET	
I-4	709.85	P-10	P-9	TYPE M INLET	
I-5	714.80	P-14	P-10	TYPE M INLET	
I-6	685.00	-	P-11	TYPE M INLET	

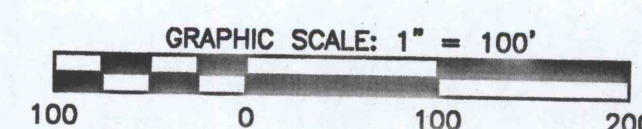

**Borton
 Lawson**
 ENGINEERING
 ARCHITECTURE
 www.borton-lawson.com

Northeast Pennsylvania

613 Baltimore Drive
 Suite 300
 Wilkes-Barre, PA 18702-7903

Voice: 570-821-1999
 Fax: 570-821-1990

Lehigh Valley

3893 Adler Place
 Suite 100
 Bethlehem, PA 18017

Voice: 484-821-0470
 Fax: 484-821-0474

REVISIONS

DATE: 08/04/2006
 SCALE: AS NOTED
 DR: JEB
 CH: BY:

SITE GRADING AND DRAINAGE PLAN

EARTH CONSERVANCY HUBER III
 RECLAMATION PROJECT

PENNSYLVANIA

LUZERNE COUNTY

HANOVER TOWNSHIP

PROJECT NO. 2005-1748-02

DRAWING NO.

2 of 10